




1 FIRE PROTECTION CISTERN/FIRE PUMP DETAIL - SECTION
FP0.2 N.T.S.

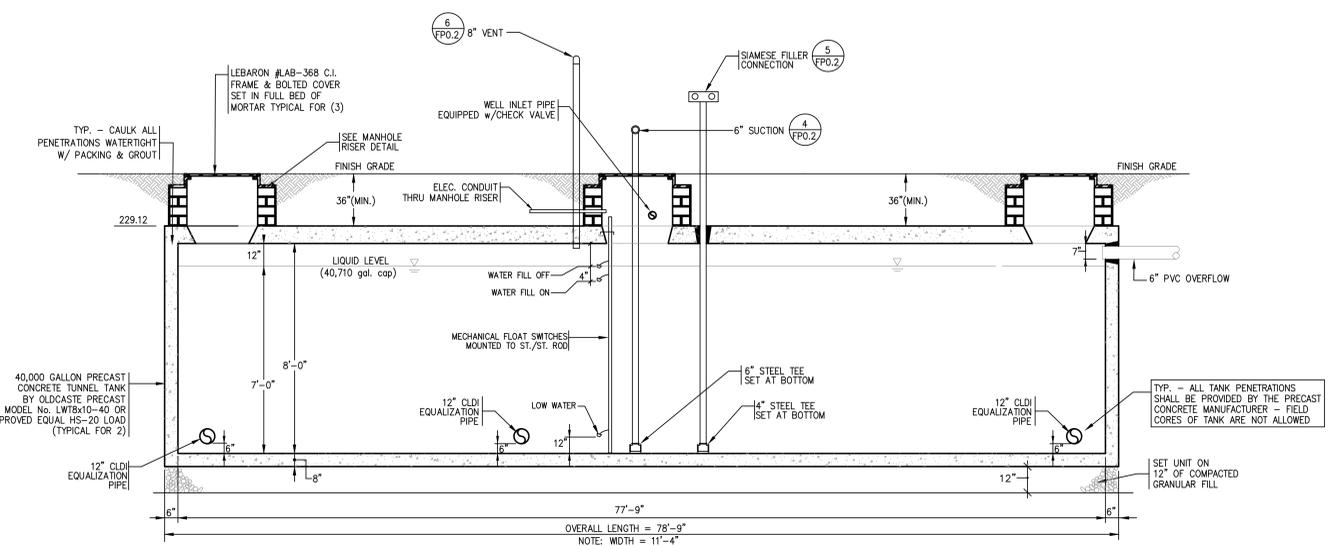


2 FIRE CISTERN DETAIL (40,000 GAL. CAP.)
FP0.2 N.T.S.

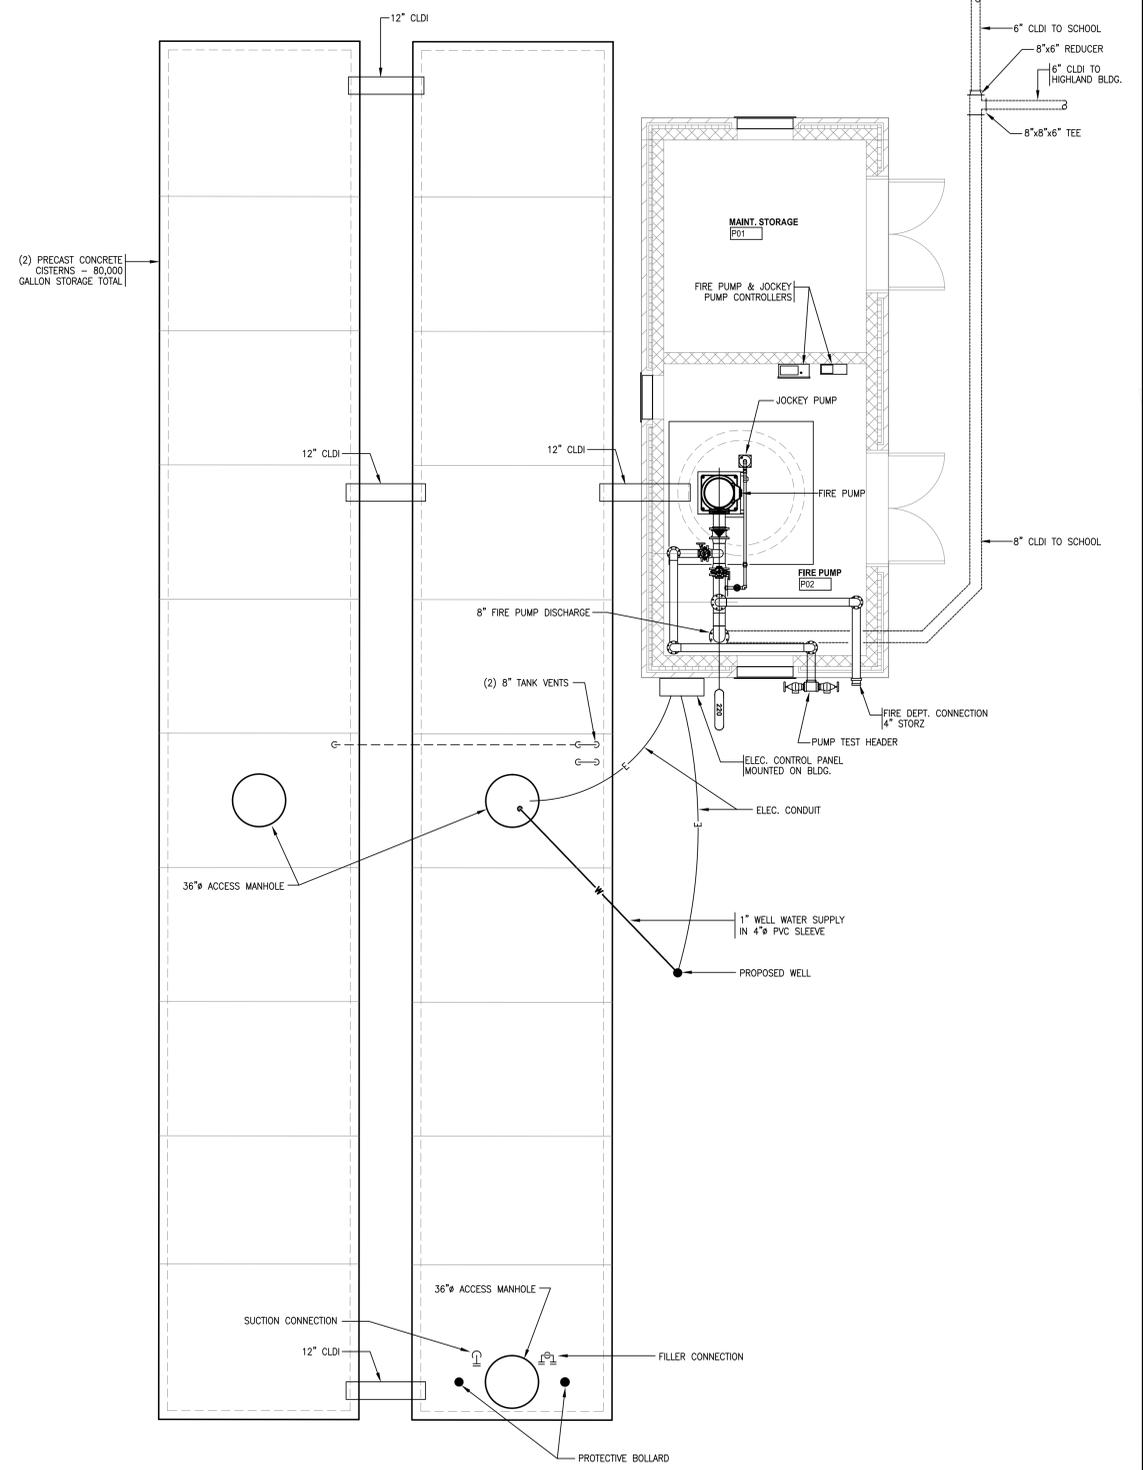


3 FIRE PUMP HOUSE & PUMP PLAN VIEW
FP0.2 NO SCALE

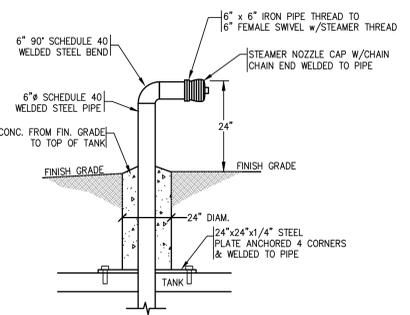

4 DRY SUCTION NOZZLE
FP0.2 N.T.S.

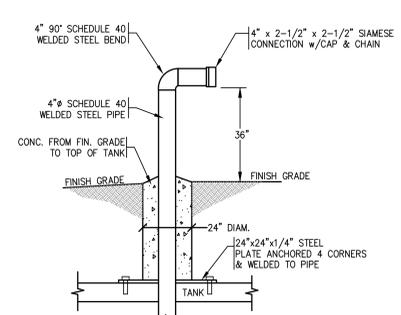


5 SIAMESE FILL PIPE
FP0.2 N.T.S.

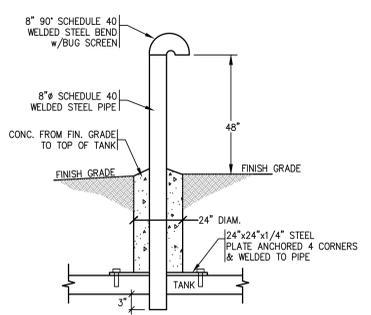

6 VENT PIPE
FP0.2 N.T.S.

CISTERN NOTES:

1. WELL PUMP SHALL BE APPROVED BY TOWN OF CARLISLE FIRE DEPARTMENT.
2. FLASHING ALARM LIGHT TO BE MOUNTED ON TOP OF CONTROL PANEL.
3. ELECTRICAL WORK SHALL BE IN COMPLIANCE WITH ALL APPLICABLE CODES AND MATERIALS SHALL BE AS SPECIFIED IN THE "CARLISLE FIRE DEPARTMENT SPECIFICATIONS FOR FIRE PROTECTION CISTERN".
4. BACKFILL SHALL BE CLEAN EARTHEN FILL WITH NO STONES LARGER THAN 1-1/2" AND COMPACTED IN PLACE.
5. CONTRACTOR IS REQUIRED TO ARRANGE THE REQUIRED INSPECTIONS WITH THE CARLISLE FIRE DEPARTMENT.
6. ALL STEEL PIPE SHALL BE PRIMED AND PAINTED FOREST GREEN BEFORE BACKFILLING.
7. CISTERN SHALL COMPLY WITH THE "TOWN OF CARLISLE SPECIFICATIONS AND REQUIREMENTS FOR FIRE PROTECTION CISTERNS" AS LAST AMENDED.

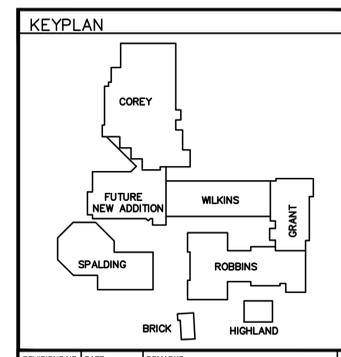

REVISIONS NO.	DATE	REMARKS	BY	DRAWING NUMBER

HMFH Architects, Inc.
 100 Bishop Allen Drive
 Carlisle, MA 02139
 P: 617.482.2200
 F: 617.482.2201
 www.HMFH.com
 Architecture • Programming • Master Planning

CHRISTOPHER M. GARCIA
 No. 49653
 PROFESSIONAL ENGINEER
 STATE OF MASSACHUSETTS

GARCIA GALLAGHER DESOUSA
 ARCHITECTS
 100 Bishop Allen Drive
 Carlisle, MA 02139
 P: 617.482.2200
 F: 617.482.2201
 www.HMFH.com

SITE PLAN REVIEW
 09-09-2010

TRUE NORTH
 PLAN NORTH

Carlisle Public School
 Carlisle, MA
Details
Fire Protection
 SCALE: 1/8" = 1'-0"
 DRAWING NUMBER
FP0.2
 JOB NUMBER 40020

CHECKED BY: CUG
 DRAWN BY: CGD